

SafetyKleen UK Limited
Distribution Centre
Todwick Road Industrial Estate
Bookers Way
Dinnington
Sheffield S25 3SH

Telephone: 01909 519300
Facsimile: 01909 519302
E-mail: skuk@sk-europe.com
Website: www.sk-europe.com



Louise Wild
Environment Agency
Permitting Officer
National Permitting Service Cambria House
29 Newport Road
Cardiff
CF24 0TP

4th June 2008

Dear Louise,


Please find enclosed 4 revised diagrams describing the location of the proposed aqueous bulk storage tank as discussed on the telephone. Please could you append the diagrams to the working plan dated the 14.04.08 rev 3. I hope this will be to your satisfaction however should you have any questions please do not hesitate to contact me. Many thanks in advance.

Yours sincerely


Glenn Evans

Environmental Compliance Manager / DGSA




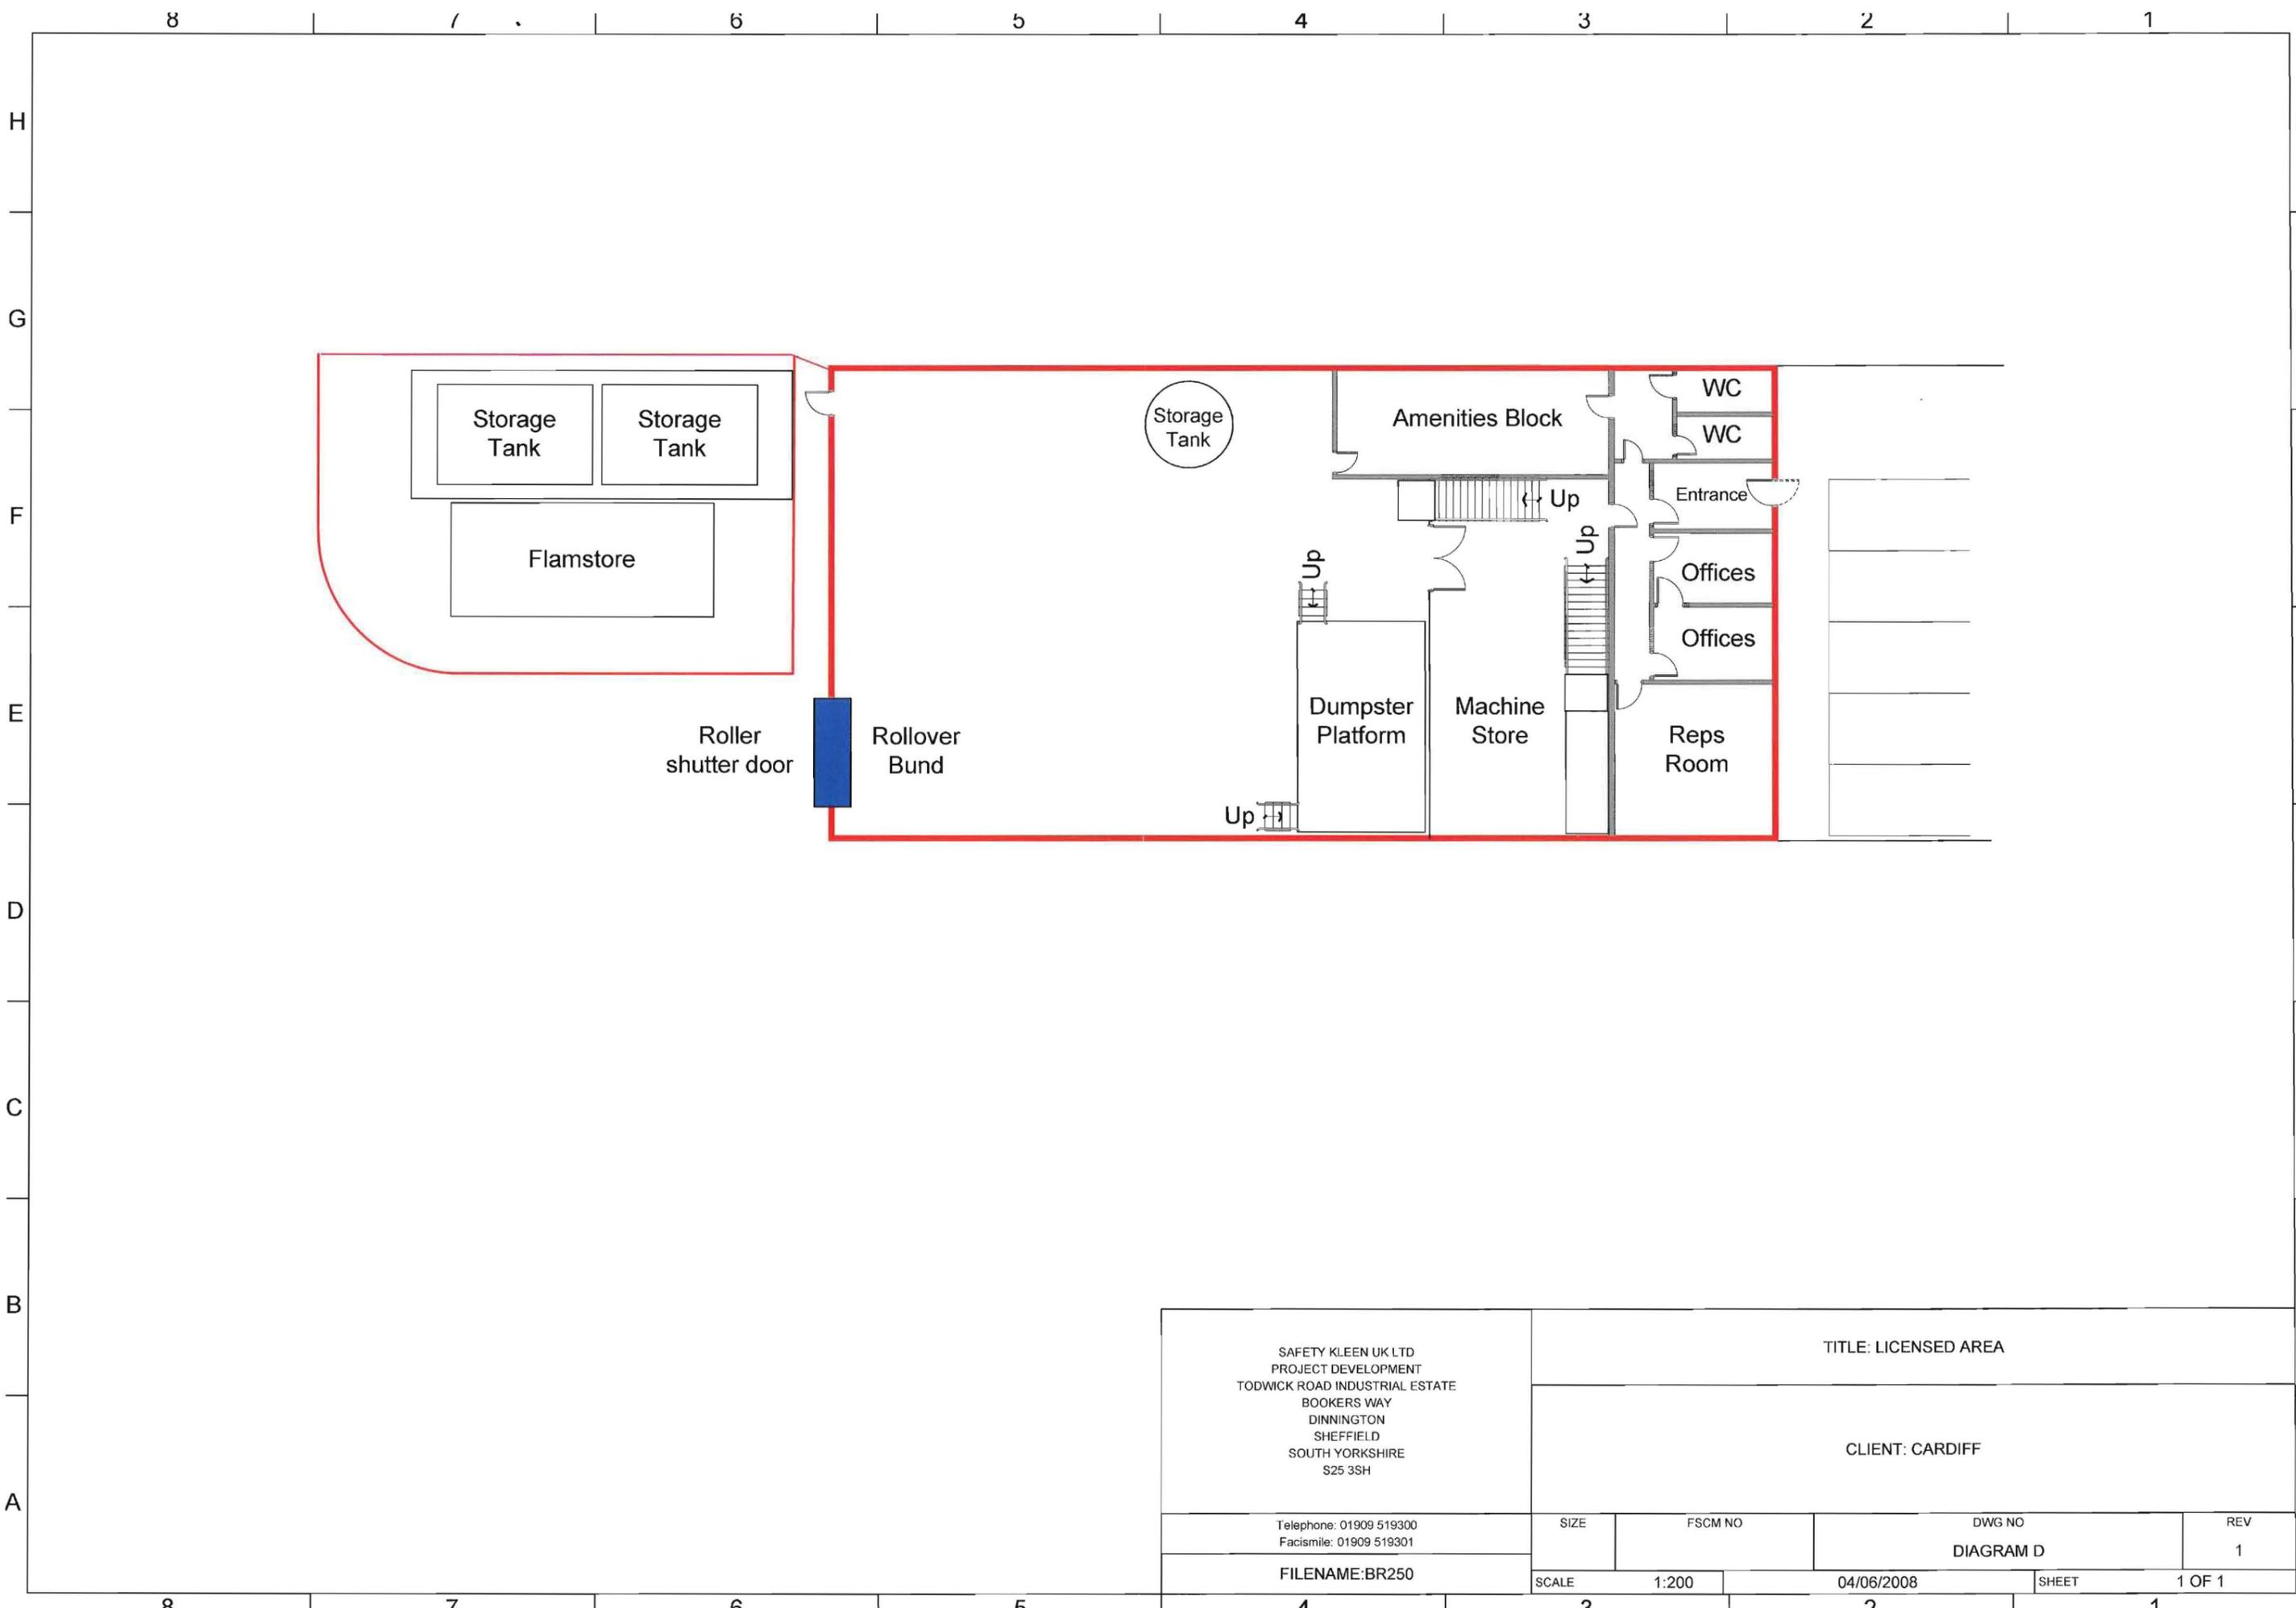

SAFETY KLEEN UK LTD PROJECT DEVELOPMENT TODWICK ROAD INDUSTRIAL ESTATE BOOKERS WAY DINNINGTON SHEFFIELD SOUTH YORKSHIRE S25 3SH		TITLE: LICENSED AREA			
		CLIENT: CARDIFF			
Telephone: 01909 519300 Facimile: 01909 519301	SIZE	FSCM NO	DWG NO DIAGRAM D	REV 1	
FILENAME: BR250	SCALE 1:200	04/06/2008	SHEET	1 OF 1	

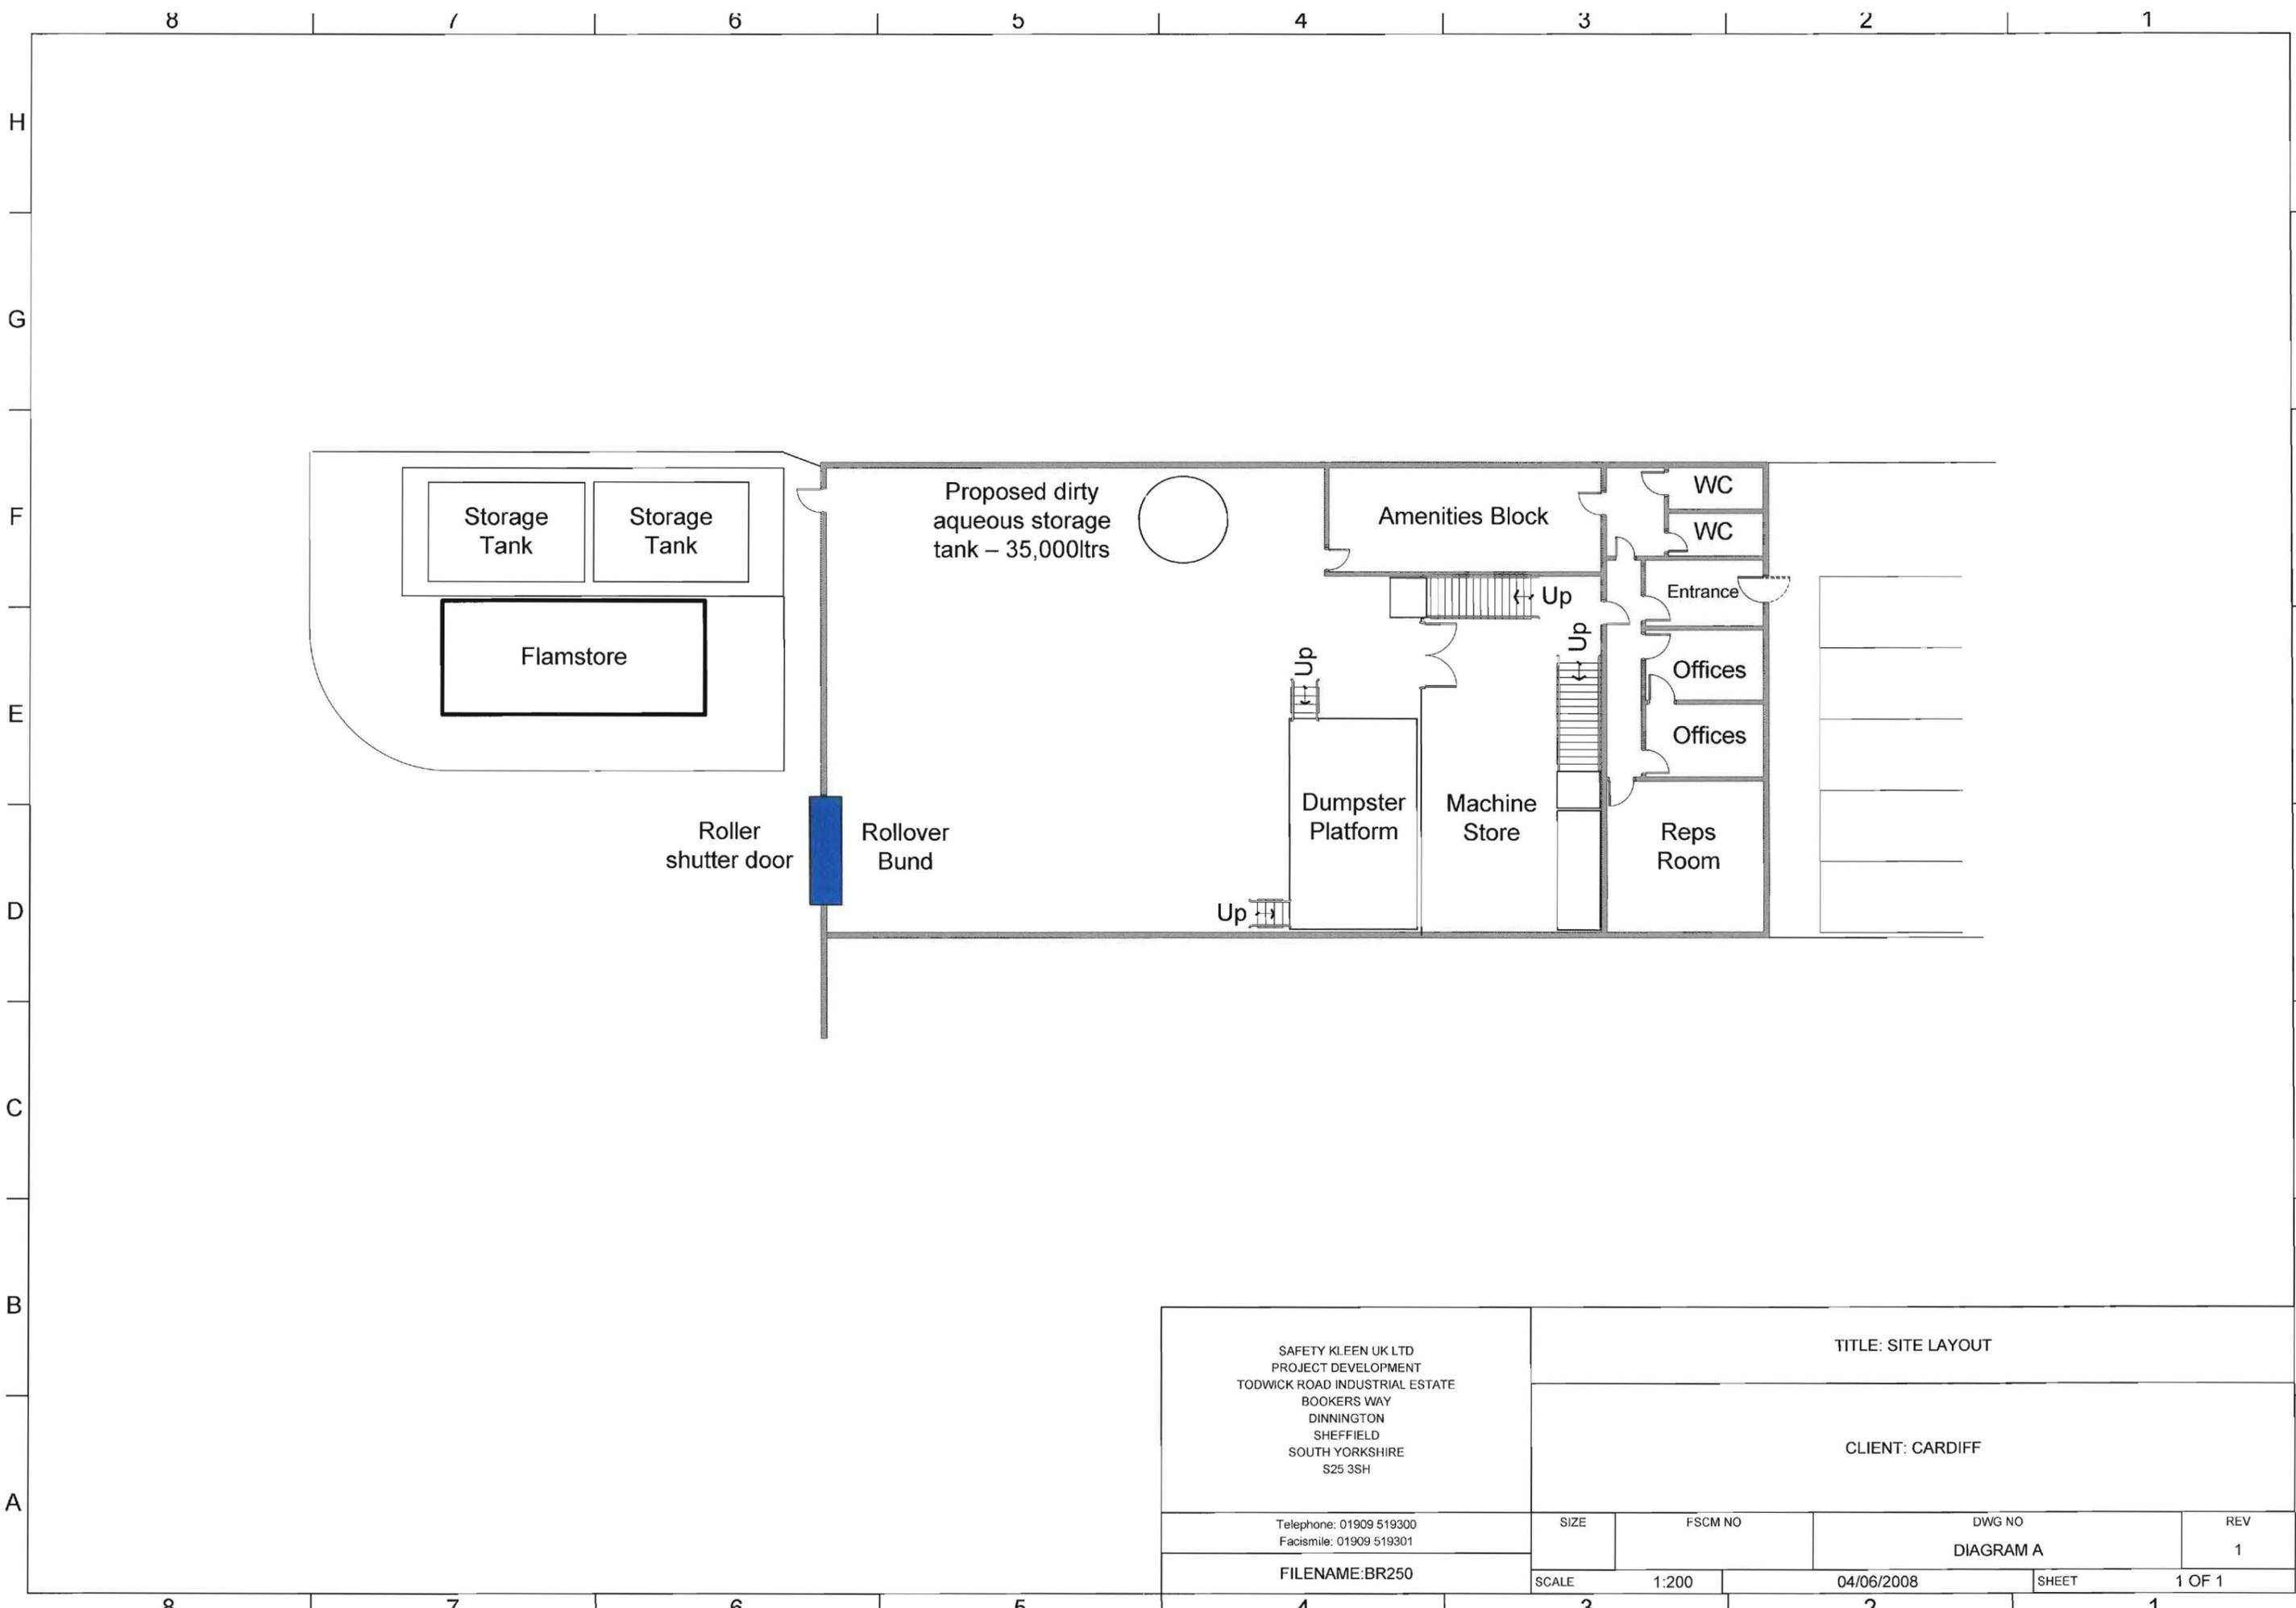

SAFETY KLEEN UK LTD PROJECT DEVELOPMENT TODWICK ROAD INDUSTRIAL ESTATE BOOKERS WAY DINNINGTON SHEFFIELD SOUTH YORKSHIRE S25 3SH		TITLE: SITE LAYOUT		
Telephone: 01909 519300 Facsimile: 01909 519301		CLIENT: CARDIFF		
FILENAME: BR250	SIZE	FSCM NO	DWG NO DIAGRAM A	REV 1
	SCALE 1:200	04/06/2008	SHEET	1 OF 1

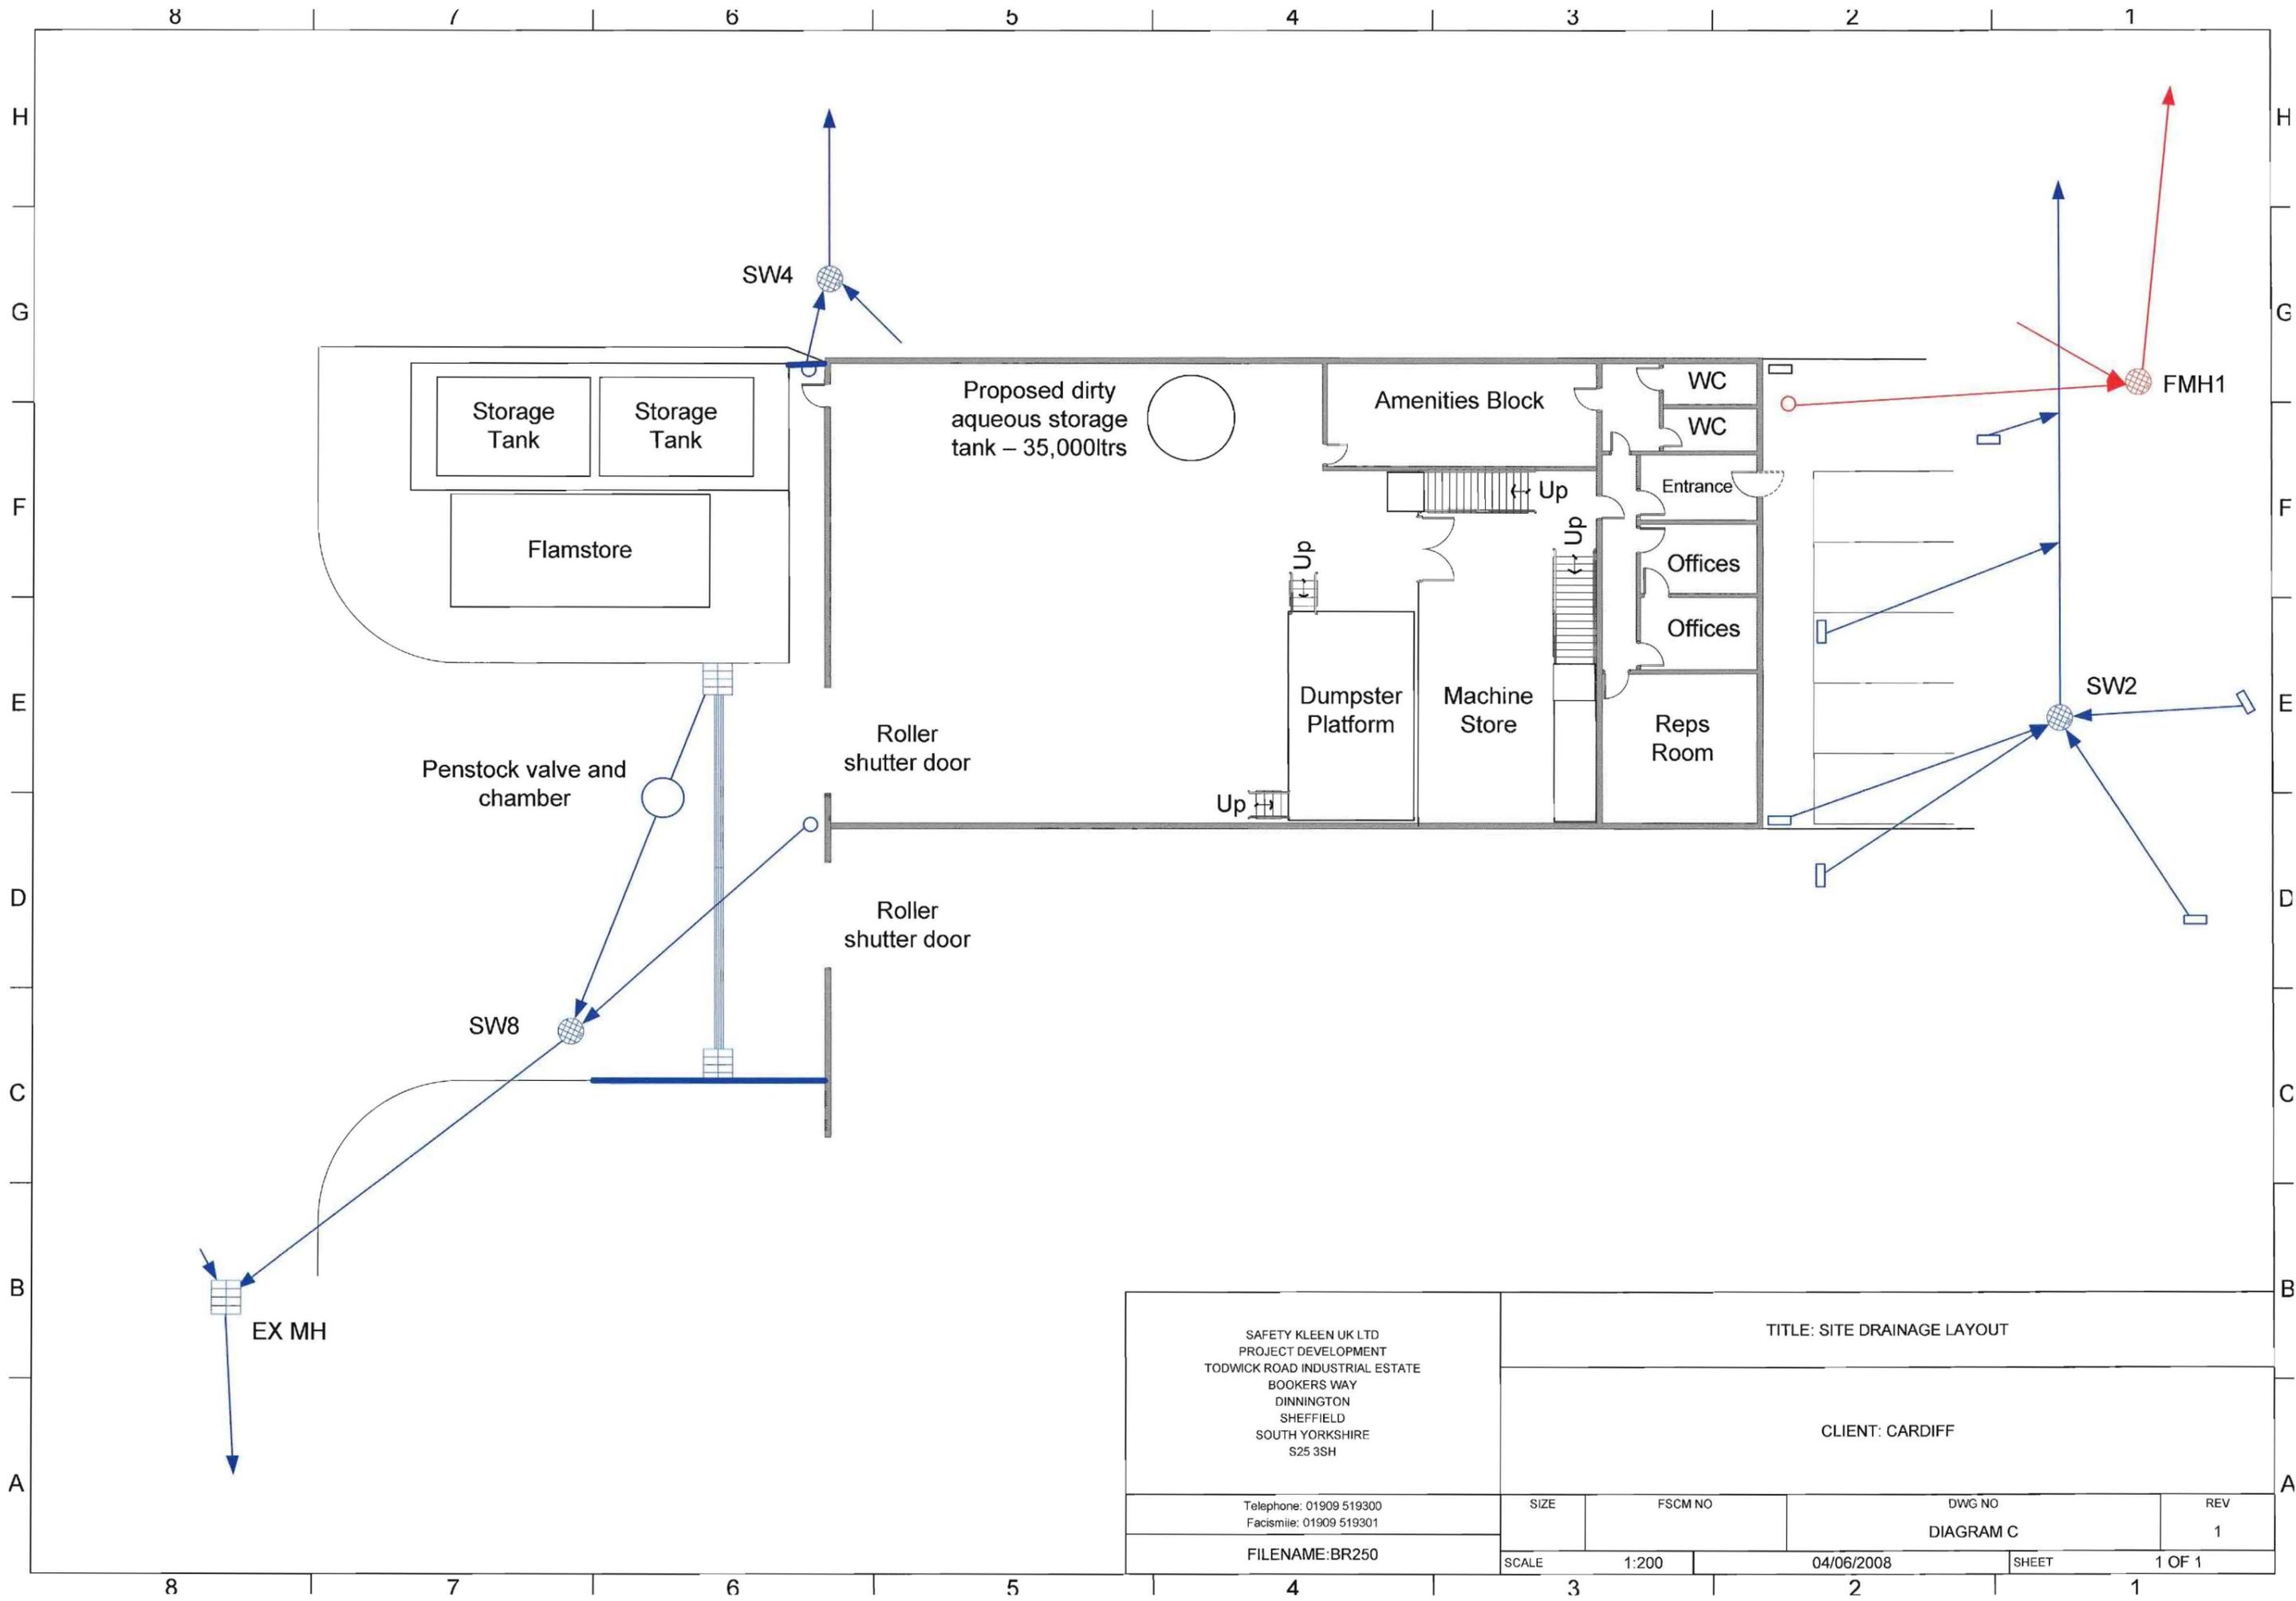

SAFETY KLEEN UK LTD
 PROJECT DEVELOPMENT
 TODWICK ROAD INDUSTRIAL ESTATE
 BOOKERS WAY
 DINNINGTON
 SHEFFIELD
 SOUTH YORKSHIRE
 S25 3SH


Telephone: 01909 519300
 Facsimile: 01909 519301

FILENAME: BR250

TITLE: SITE DRAINAGE LAYOUT

CLIENT: CARDIFF

SIZE	FSCM NO	DWG NO	REV
SCALE	1:200	04/06/2008	1
DIAGRAM C		SHEET 1 OF 1	

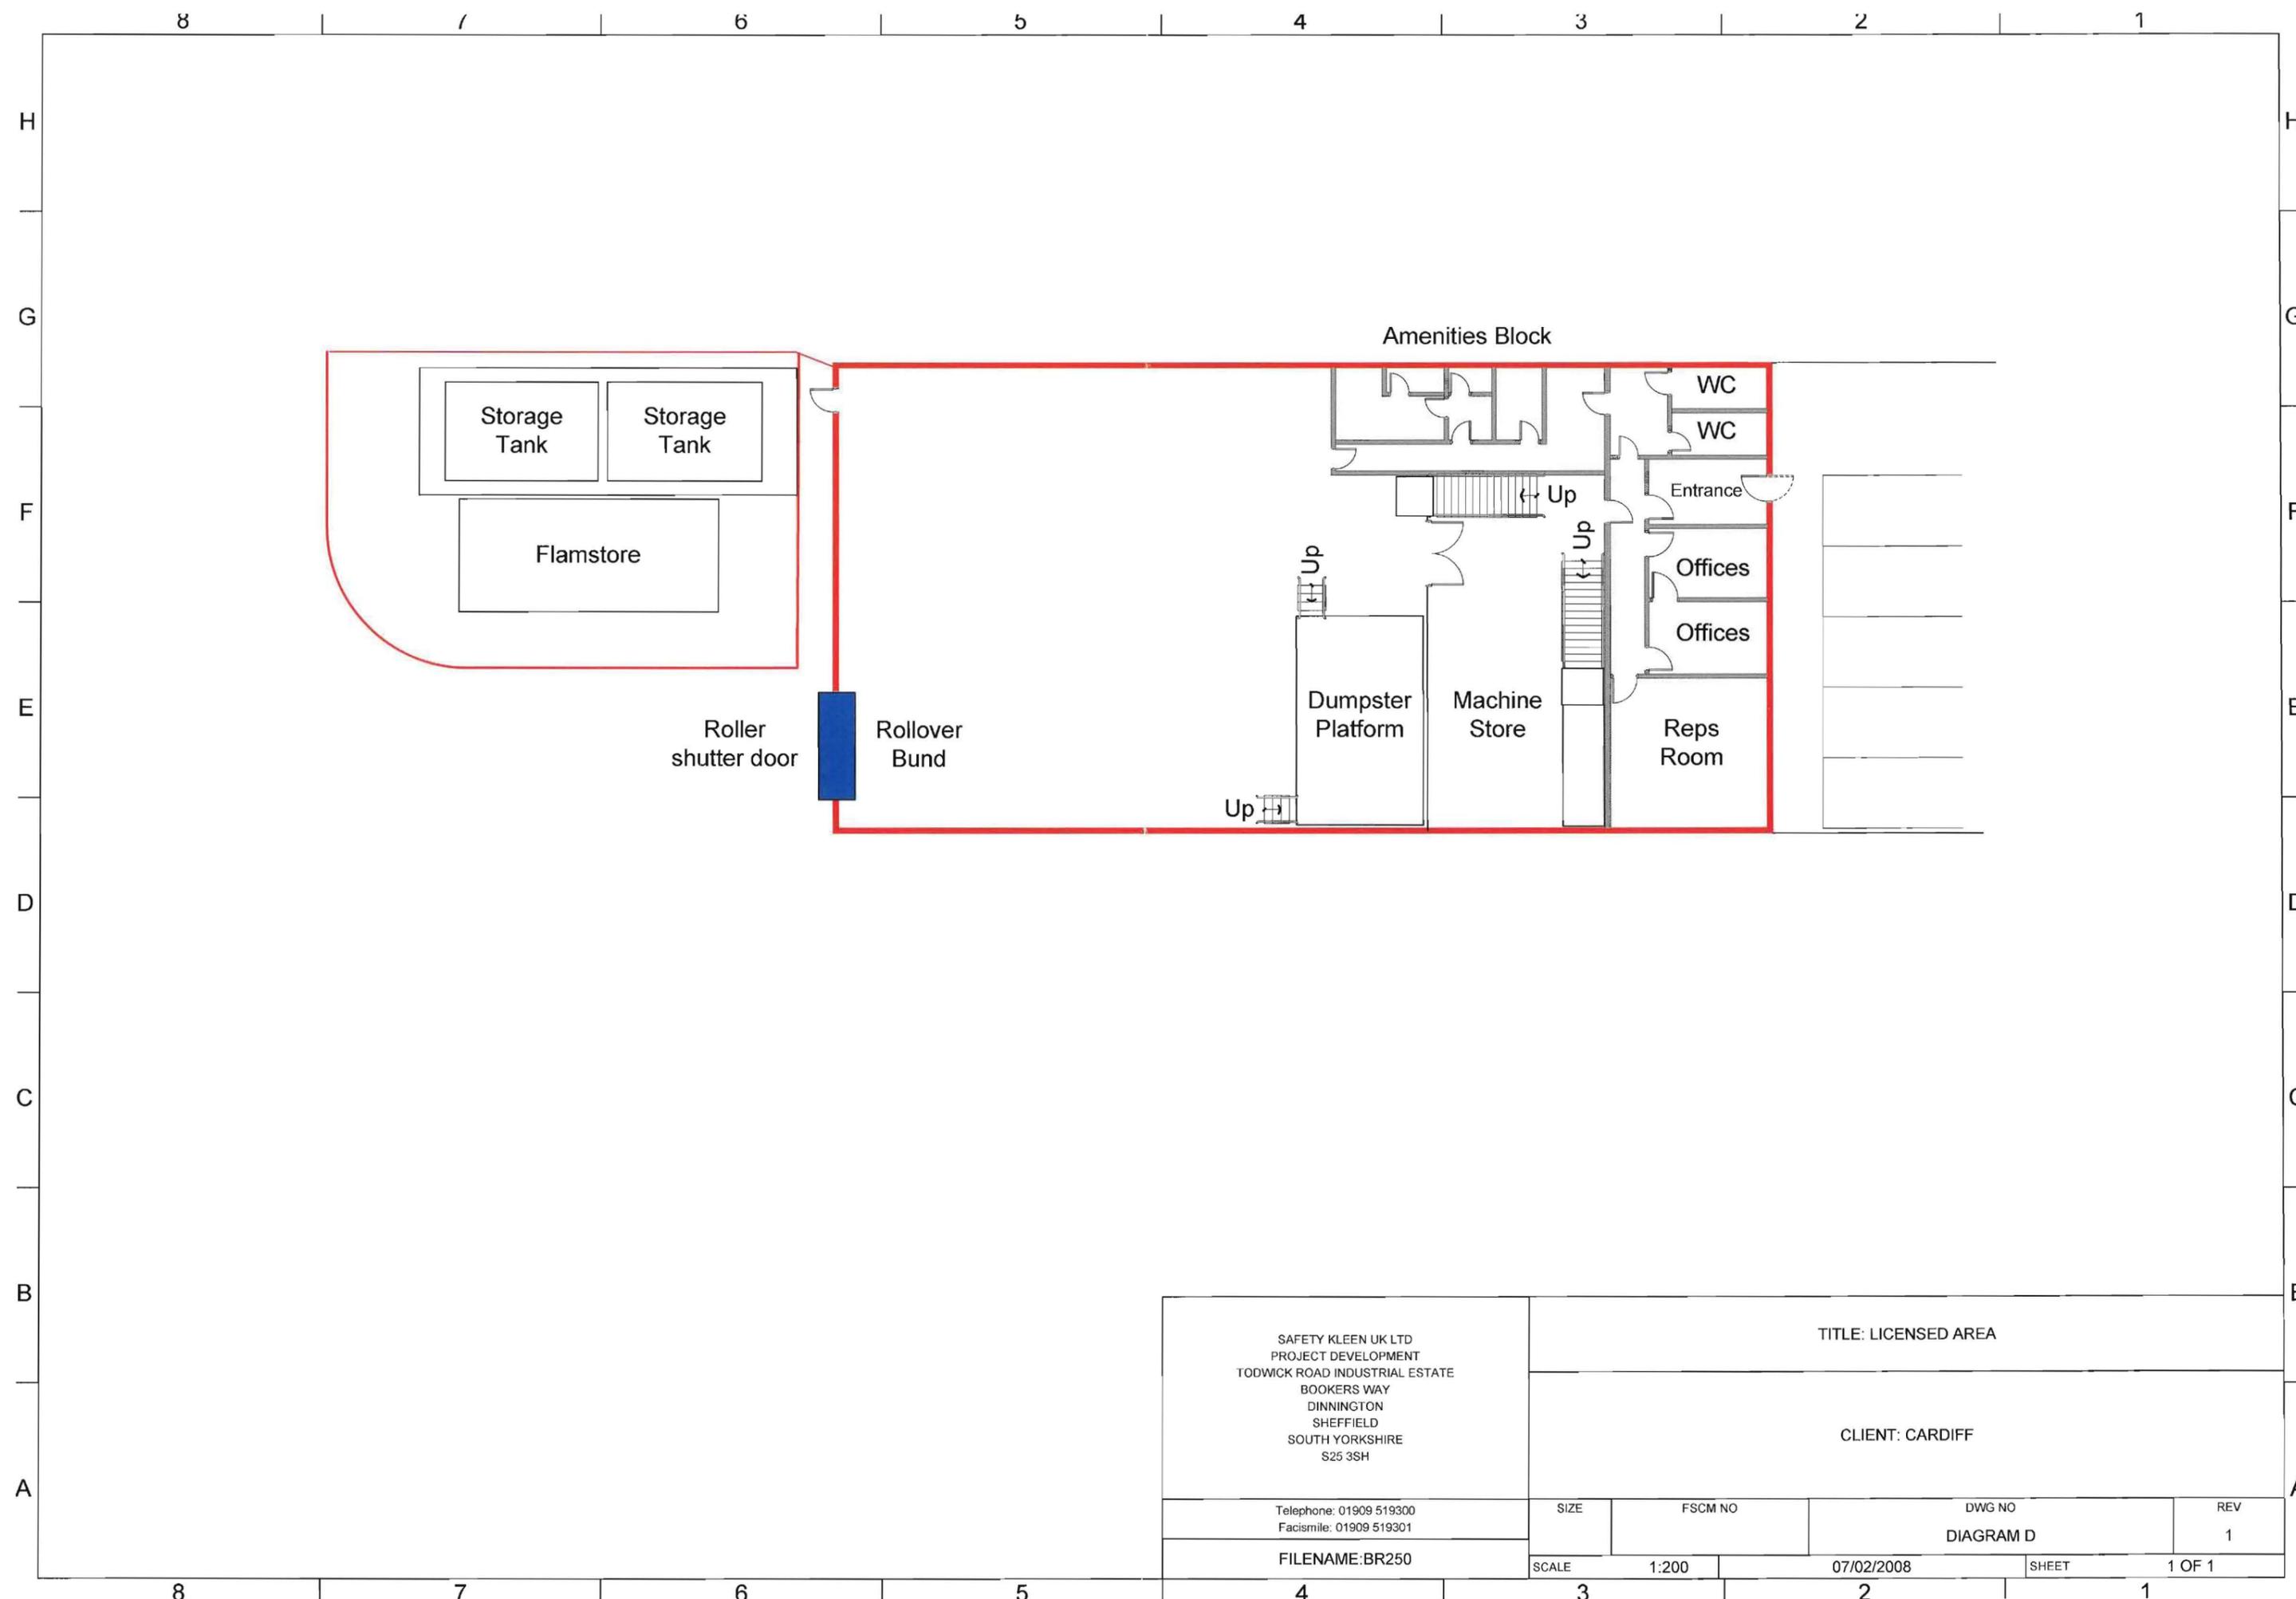

SAFETY KLEEN UK LTD PROJECT DEVELOPMENT TODWICK ROAD INDUSTRIAL ESTATE BOOKERS WAY DINNINGTON SHEFFIELD SOUTH YORKSHIRE S25 3SH		TITLE: LICENSED AREA			
		CLIENT: CARDIFF			
Telephone: 01909 519300 Facimile: 01909 519301		SIZE	FSCM NO	DWG NO	REV
FILENAME: BR250		SCALE	1:200	07/02/2008	DIAGRAM D 1
				SHEET	1 OF 1