


COLOUR KEY	
EFFLUENT	Red line
CHEMICALS	Green line
SLUDGE	Yellow line
WATER	Blue line
AIR	Purple line

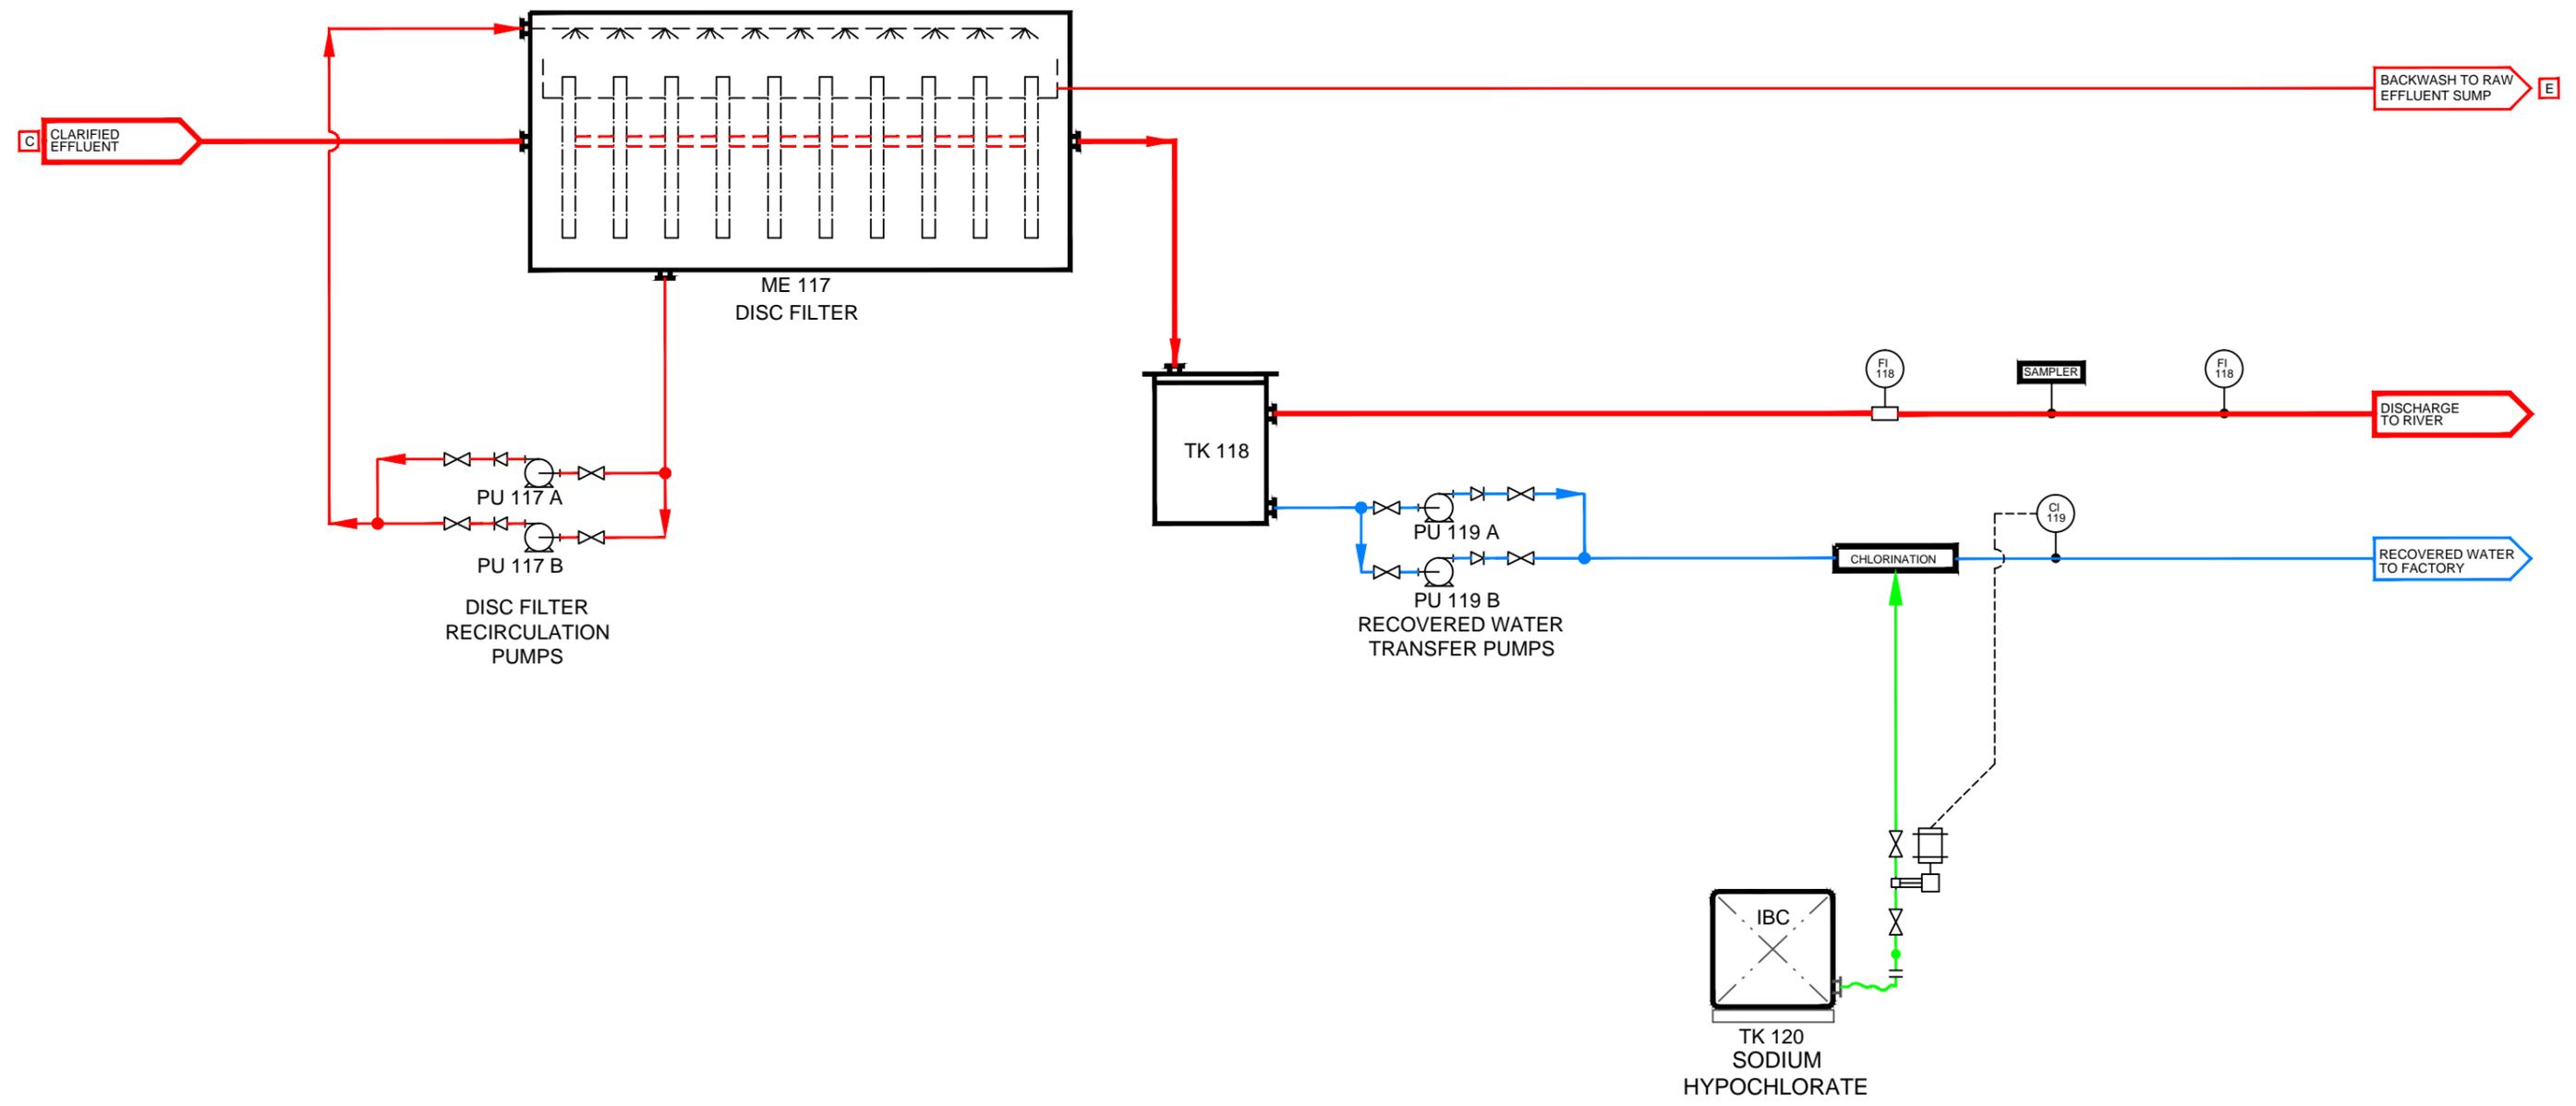

Appendix F1 - Figure 6

REV	DATE	BY	DESCRIPTION	REV	DATE	BY	DESCRIPTION
D	06.06.16	AS	WATER RECOVERY ADDED				
C	03.07.15	AS	REVISED				
B	19.01.16	DL	REVISED				
A	11.01.16	AS	FIRST ISSUE				

This drawing is issued on the condition that it is not copied in full or in part, or its contents communicated to any party without first obtaining the permission of CAP Technology Ltd

**C.A.P. Technology**
  
 Unit 4a, Hampton Heath Ind. Est.,
   
 Malpas, Cheshire. SY14 8LU
   
 Tel: 01948 820317 Fax: 01948 820578

DIMENSIONS IN MILLIMETERS  
UNLESS OTHERWISE STATED

Untoleranced Dimensions

Fabrication	± 1mm
Machining	± 0.1mm
Angular	± 1/2°

MATERIAL	N/A
FINISH	N/A
SCALE	N/A
DWG. SIZE	A3
DRAWN BY	A Shackleton
DATE	11.01.16
CHECKED BY	

TITLE		EFFLUENT TREATMENT PLANT P&ID WATER RECOVERY	
CLIENT		SALISBURY POULTRY	
CONTRACT NUMBER	DRAWING NUMBER	SHEET	REV
--	SBP-003	4 Of 4	D