


EXTRACT FROM ORDNANCE SURVEY.  
 REPRODUCED FROM THE ORDNANCE SURVEY MAPPING WITH THE PERMISSION OF THE CONTROLLER OF HER MAJESTY'S STATIONERY OFFICE.  
 UNAUTHORISED REPRODUCTION INFRINGES CROWN COPYRIGHT AND MAY LEAD TO PROSECUTION OR CIVIL PROCEEDINGS.  
 PEMBROKESHIRE C.C. LOCAL AUTHORITY LICENCE No LA 100023344

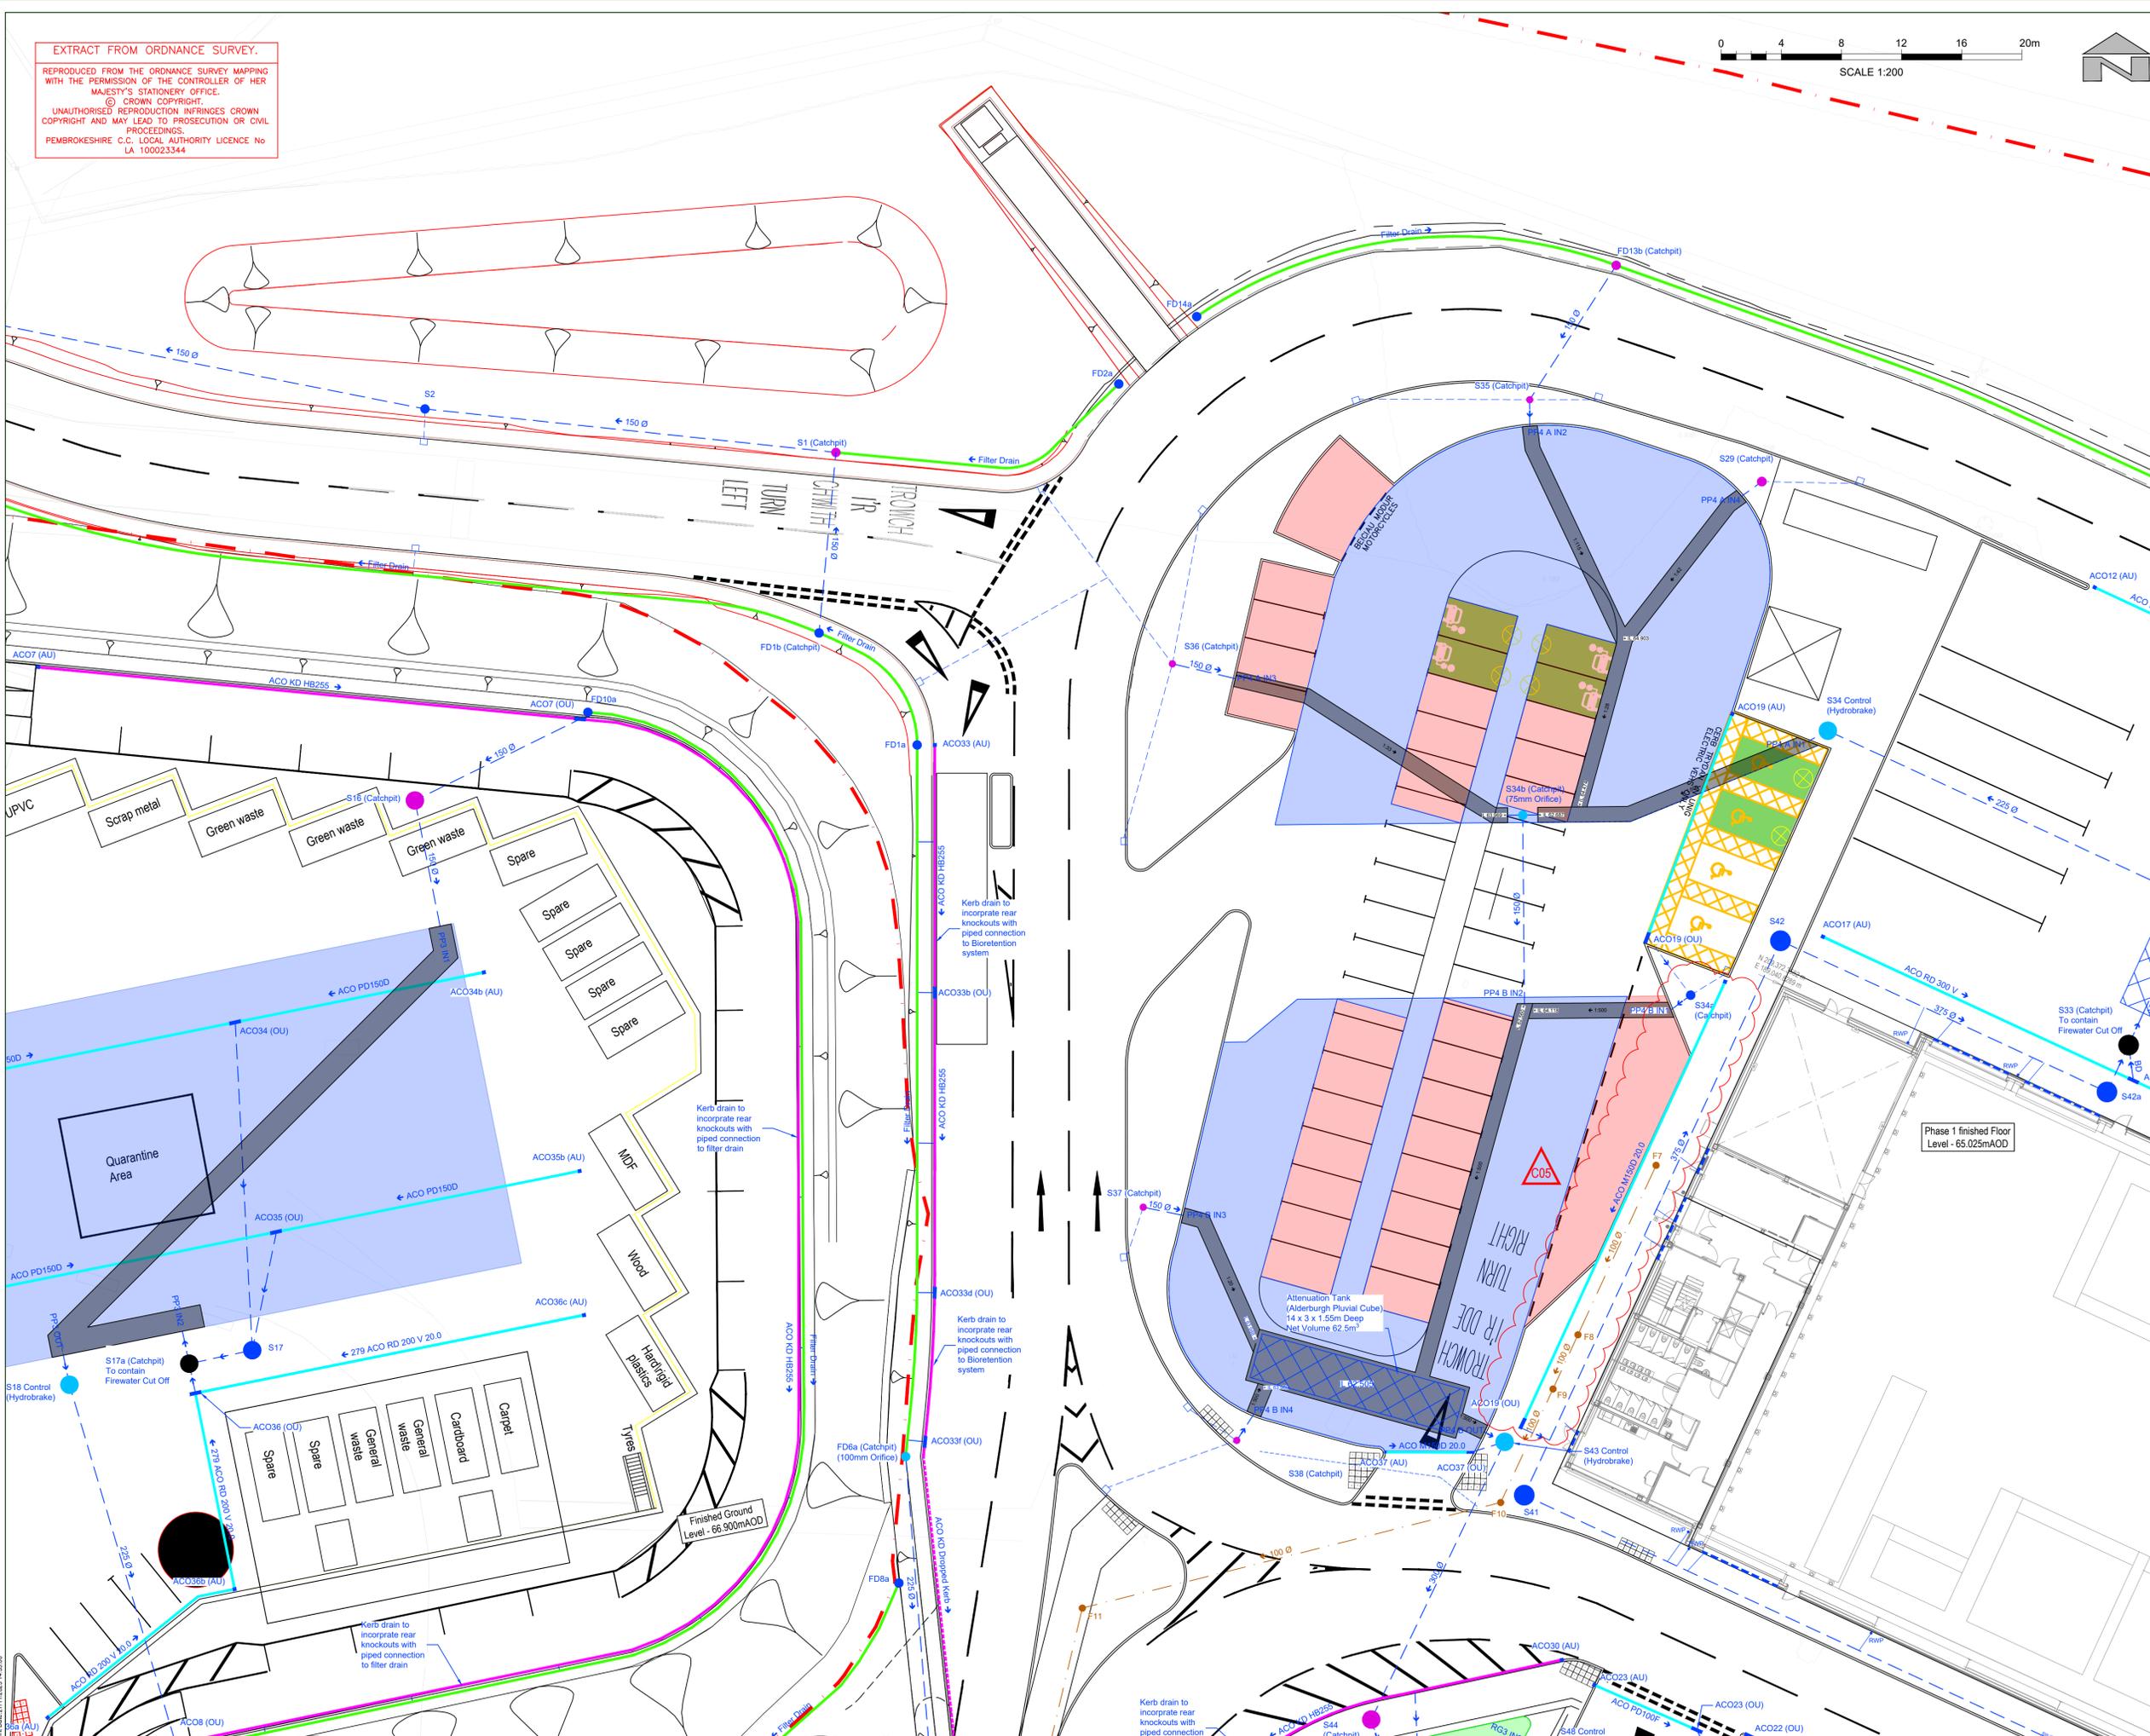

- Notes:
- General:
- All dimensions and levels are in metres.
  - Do not scale from this drawing. Use figured dimensions only.
  - All existing assets to be protected during construction.
  - SuDS maintenance regime to be implemented in accordance with the recommendations in the SuDS Manual (CIRIA C753) and manufacturers instructions.
  - Backfill requirements to specification for highway works MCHW Vol. 1.
  - Pervious pavements designed to a CBR value of 2.5%. Contractor to proof roll subgrade prior to construction, any identified soft spots are to be excavated and replaced with compacted Type 1 granular material to MCHW Vol. 1 Cl. 803.
- Concrete:
- Blinding and infill concrete to be grade ST2 to BS 8500.
  - Mass concrete surround to pipes, access chambers, gullies and kerbs etc. to be grade ST4 to BS 8500.
  - Concrete to benching to be formed with a rough key to receive a 20mm thick granolithic render trowelled hard with a steel trowel to provide a dense, durable surface.
  - Buried concrete AC-2 and DS-2.
- Granular Material:
- Type 1 granular material to MCHW Vol.1 Cl. 803.
  - 4/20 clean open graded stone to BS EN 1242:2000.
  - 6F2 material to Table 6.1 of MCHW Vol.1 Series 600.
- Pipework:
- All pipework & fittings to be OSMA drain or OSMA ultra rib, or similar approved.
  - The length of pipework between access covers to include for any short length pipes as necessary to achieve the configuration of rocker pipes and standard short length pipes at fixed access chamber positions.
  - All pipework built into access chambers to be either standard short lengths or cut lengths as appropriate.
  - Rocker pipes to be a maximum of 600mm long.
  - All 'Y' connections to be formed utilising proprietary junction sections.
- Brickwork:
- Where required, brickwork to access chambers and gullies to be Class B engineering brickwork to BS 771 laid in English bond 225mm thick with Class M6 (Class 2) mortar, flush pointed.
- Access Covers and Gratings:
- All access covers in trafficked areas to be non-rocking type, single sealed, locking and load class D400.
  - All access covers in non-trafficked areas to be non-rocking type, single sealed, locking and load class B125.
  - All internal foul access covers are to be pre-fabricated type, hung from suspended floor slab.

**SAFETY, HEALTH AND ENVIRONMENTAL INFORMATION**

IN ADDITION TO THE HAZARDOUS RISKS NORMALLY ASSOCIATED WITH THE TYPES OF WORK DETAILED ON THIS DRAWING, NOTE THE FOLLOWING:

Location of the existing statutory services on this drawing have been interpreted from information received from the statutory providers. The site team should anticipate additional services such as street lighting and associated cabling, overhead telecons or power and storm water sewers (not shown on DCWM plans). The utilities are shown diagrammatically on this drawing and are not definitive. Location of utilities should be confirmed on site prior to construction.

- Working in or near a watercourse
- Working in or near a highway

For further details on risks refer to the designers risk assessments

IT IS ASSUMED THAT ALL WORKS WILL BE CARRIED OUT BY A COMPETENT CONTRACTOR WORKING, WHERE APPROPRIATE, TO AN APPROVED METHOD STATEMENT

Rev	Drawn	Checked	Approved	Description	Date
005	WT	SM	SM	Drainage amended to suit revised drawing	27/11/2023
004	EB	AC	SM	Drainage amended to suit revised road alignment	18/09/2023
003	AC	JC	SM	Drainage amended to suit Welsh Water Diversion	14/06/2023
002	SL	SM	SM	Drainage amended to suit updated level information	16/02/2023
001	SL	SM	BW	Construction Issue	08/02/2023
001	JH	PM	KF	Issued for Tender	27/06/2022
004	SG	PM	KF	Issued for Information	20/05/2022
003	SG	PM	KF	Issued for Information	20/04/2022
002	SG	PM	KF	Issued for Information	14/03/2022
001	SG	PM	KF	First Issue	02/02/2022

Purpose of Issue  
**A - Suitable for Construction**

Classification  
**Confidential**

Client  
  
 Pembrokeshire County Council  
 Eco Park

Drawing  
**Drainage Layout  
 Surface and Foul Water Sewers  
 Sheet 2 of 7**

Scale @ A1	Drawn	Checked	Approved
1:200	SG	PM	KF

Project No.	Date
CS/101992	19-OCT-21

Drawing Identifier  
 Project: Originator - Zone Level - File Type - Title - Number  
 PECO-CAP-PW-XX-DR-D-000503 C05

Quest House, St Mellons Business Park, Fortran Road,  
 St Mellons, Cardiff, CF3 0EY, UK  
 wsp.com