
 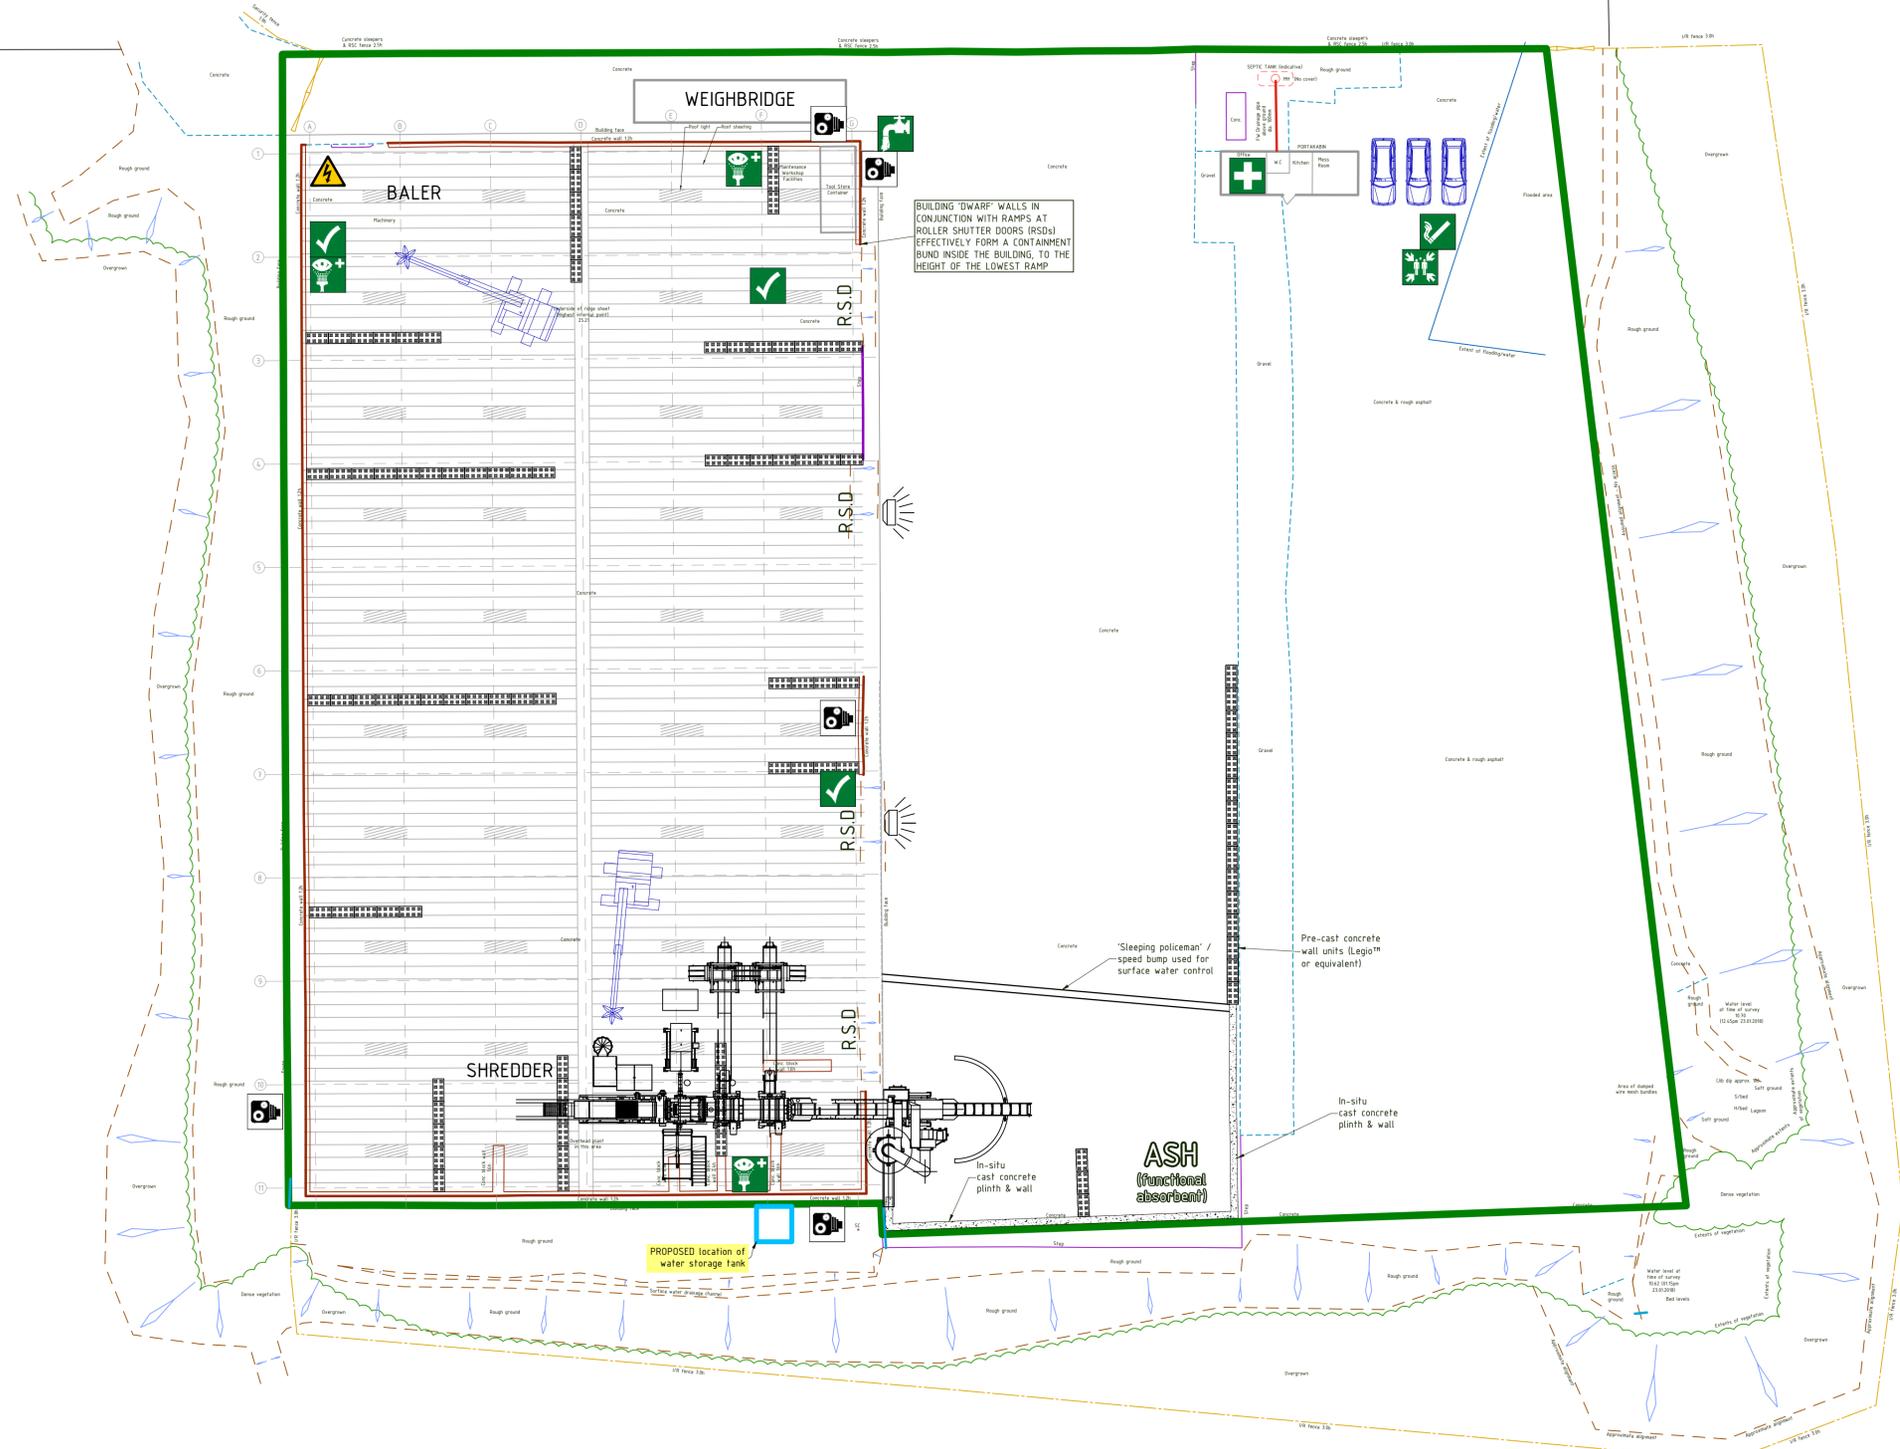


# Scrap Yard



 
## General Notes

### NOTE

There are no surface water drains or drain-holes on site

### KEY

-  Permit boundary
-  Marshalling Point
-  First Aid Kit
-  Eye Wash Station
-  Closed Circuit Television Camera
-  Water Isolation Point
-  Permitted Smoking Area
-  Electrical Isolation Point
-  Spill Kit



Reproduced from Ordnance Survey VectorMap District Raster data © Crown copyright 2018. All rights reserved. Licence number 0100031673

A	Outside storage bays removed	June 2018
No.	Revision/Issue	Date




Drawing Title, Project Name and Address  
**FIRE PROTECTION PLAN - SITE INFRASTRUCTURE**  
 Morris & Co (Handlers) Ltd  
 Top Shed, Neath Abbey Wharf  
 Skewen,  
 Neath, SA10 6BL

Project	MORRIS & Co	Drg No	07
Date	February 2018		REV A
Scale	1:250 @ A1		