


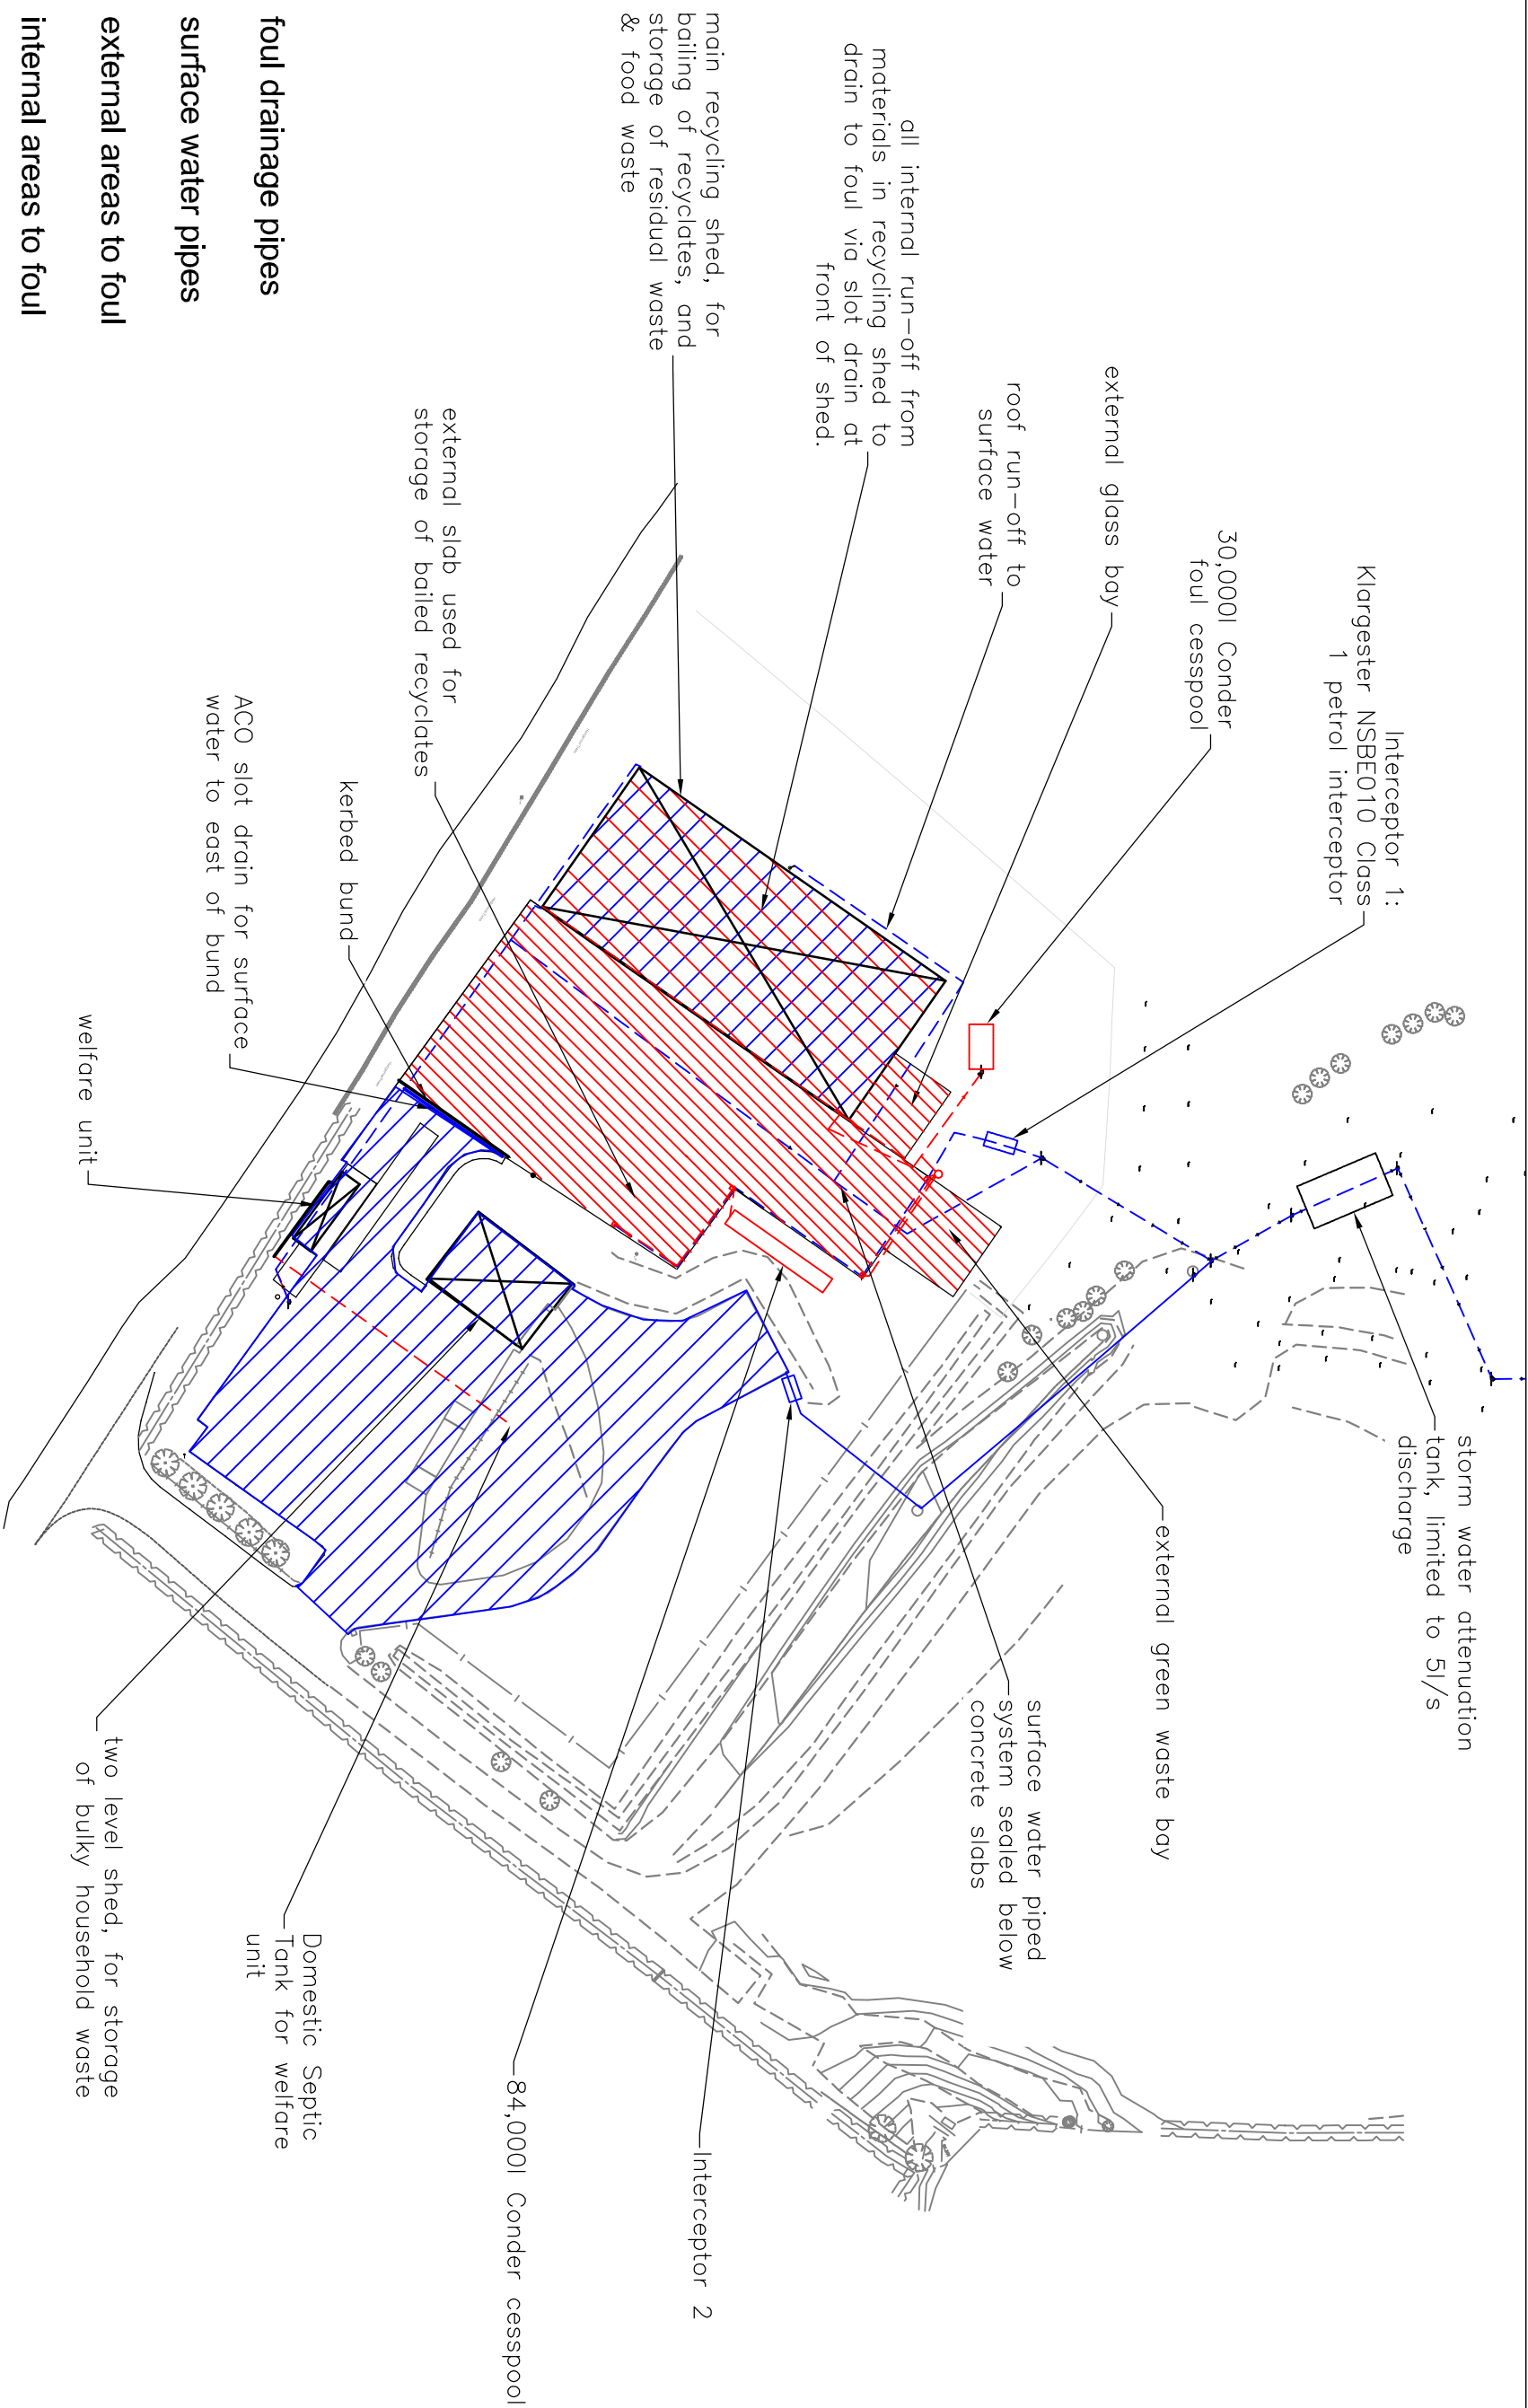

foul drainage pipes

surface water pipes

external areas to foul

internal areas to foul

external areas to surface water



EDS Regional Manager : John Edwards

EDS Regional Manager : John Edwards

71C71C C4C1

60C710



© Hawlfraeth y Goron a hawliau cronfa ddiata 2016 Arching Ordians 100024419 (Cyngor Sir Ceredigion) & 100025371 (Cyngor Sir Powys)
Crown copyright and database rights 2016 Ordnance Survey 100024419 (Ceredigion County Council) & 100025371 (Powys County Council)

CMIC is the Central Wales Infrastructure Collaboration project between Powys County Council and Ceredigion County Council and all copyrights are vested in each respective Authority.

This drawing is the property of CMIC Engineering Design Services and is issued on the condition that it is not copied, reproduced, retained or disseminated to any unauthorised person, either wholly or in part without the consent in writing of CMIC Engineering Design Services.

Project	Brecon Waste Transfer Station
Drawing Title	Site Drainage Plan

Project Number		Drawing Number		Revision	
2321		2321/D/001			
Date : 03/17		Scale at A3 1:1000			
Drawn by : SIV					
Checked by :					
Drawing Filename : - D001 site drainage plan.dwg					
Last saved : - 17/03/2017					